



5 NEW LIGHT FIXTURE, TYPE A DETAIL
1/2" = 1'-0"

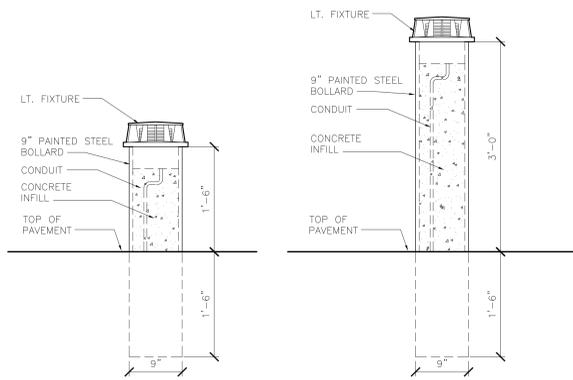

3 BOLLARD FIXTURE TYPE 1
1" = 1'-0"

4 BOLLARD FIXTURE TYPE 2
1" = 1'-0"

2 SITE LOCATION PLAN
N.T.S.

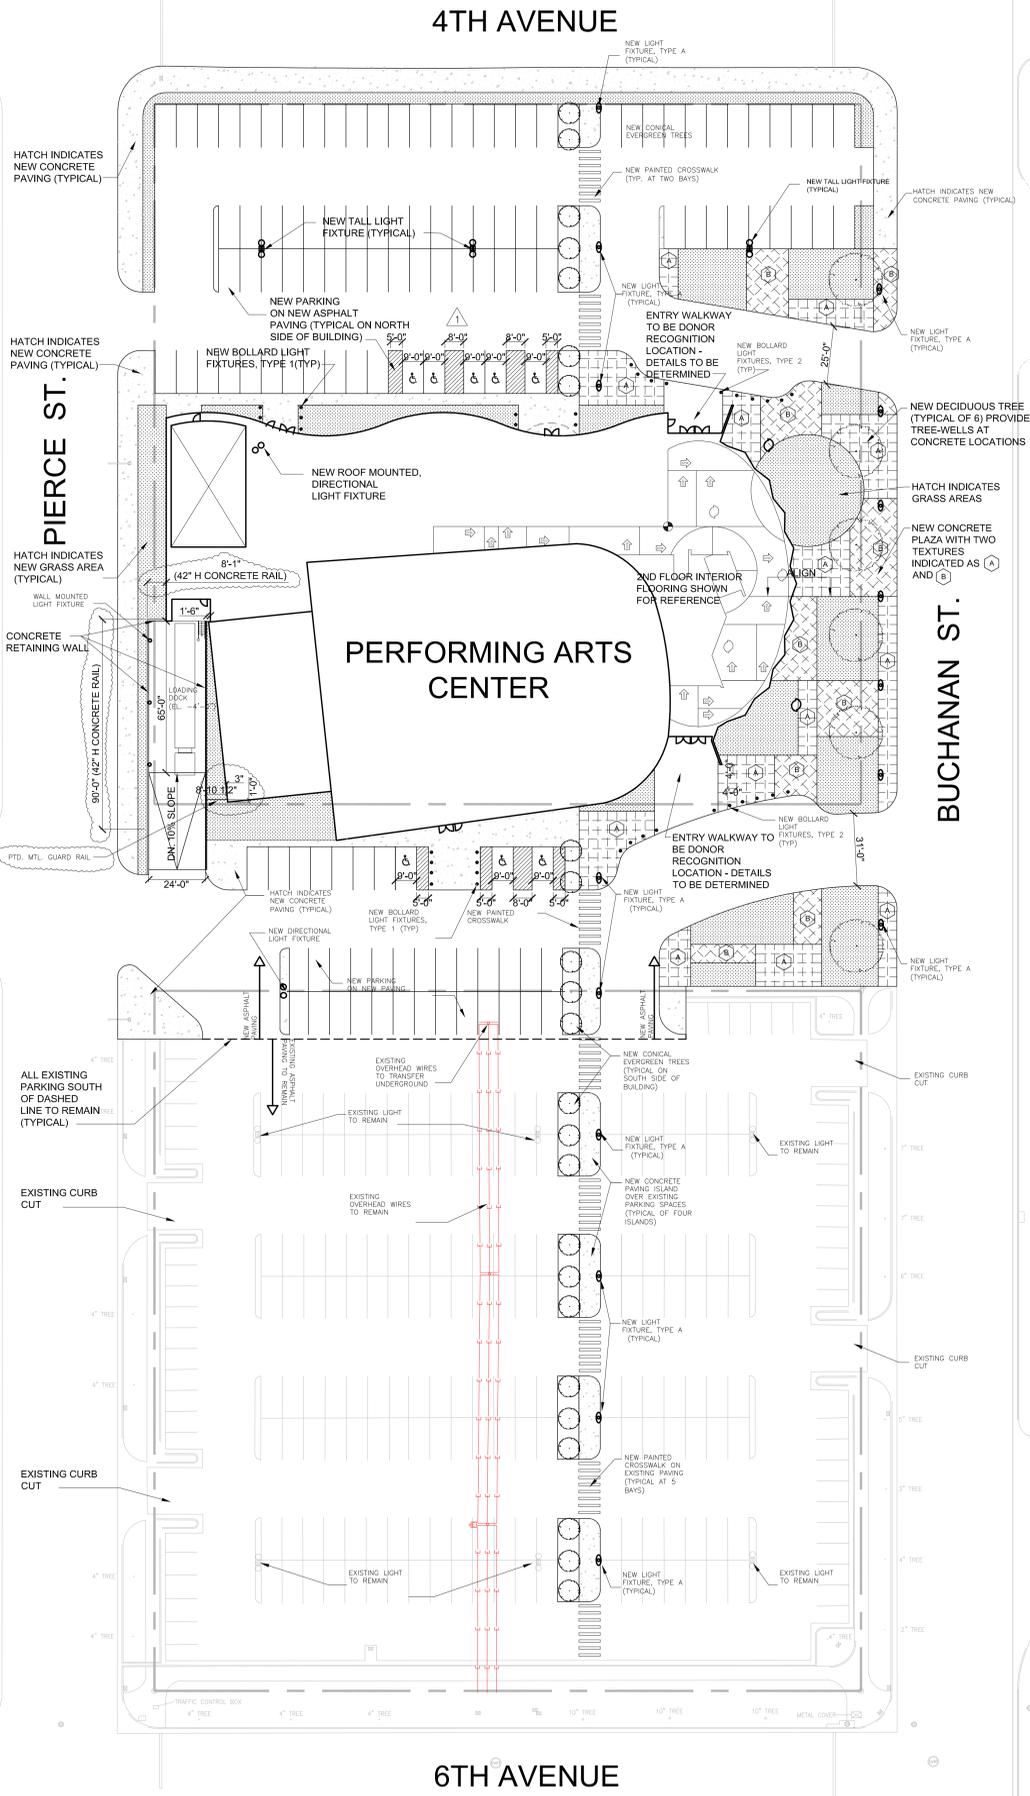

1 SITE PLAN
SCALE 1" = 30'-0"



EXISTING CIVIC CENTER

SOUTHWEST CENTER FOR THE PERFORMING ARTS
AMARILLO, TEXAS

ARCHITECT OF RECORD:
HOLZMAN MOSS ARCHITECTURE, LLP
214 WEST 20TH STREET TOWER
7TH FLOOR
NEW YORK, NEW YORK 10011
WWW.HOLZMANMOSS.COM
TEL: 212.465.0909 FAX: 212.465.2226

MECHANICAL, ELECTRICAL, PLUMBING, & FIRE PROTECTION ENGINEERS:
HLM DESIGN
1311 NORTH HARBELL AVENUE SUITE 200
DALLAS, TEXAS 75244
TEL: 214.824.3800
FAX: 214.824.6707

STRUCTURAL ENGINEERS:
ARCHITECTURAL ENGINEERS COLLABORATIVE
LITTLEFIELD BUILDING
108 EAST SIXTH STREET SUITE 400
AUSTIN, TEXAS 78701
TEL: 512.472.2111
FAX: 512.472.2122

ACOUSTICIAN:
JAFFE HOLDEN ACOUSTICS, INC.
214 WASHINGTON STREET
NORWALK, CONNECTICUT 06854
TEL: 203.836.4167
FAX: 203.836.4168

THEATER CONSULTANT:
ROBERT DAVIS, INC.
27 WEST 20TH STREET
NEW YORK, NEW YORK 10011
TEL: 212.924.9999
FAX: 212.924.2743

CIVIL ENGINEERS:
PARKHILL SMITH & COOPER
801 S. FILLMORE, SUITE 400
AMARILLO, TEXAS 79101
TEL: 806.376.8000
FAX: 806.376.8100

FIRE PROTECTION:
ROLF JENSEN & ASSOCIATES INC.
1301 NORTHWEST FREEWAY, SUITE 330
HOUSTON, TEXAS 77040-0215
TEL: 713.462.1540
FAX: 713.462.0812

SPECIFICATIONS:
CONSTRUCTION SPECIFICATIONS INC.
32 TOSHAW ROAD, P.O. BOX 480
MORGANVILLE, NEW JERSEY 07951
TEL: 732.976.0190
FAX: 732.976.0790

CONSTRUCTION MANAGER:
HUNT CONSTRUCTION GROUP
4099 McEVEN ROAD, SUITE 400
DALLAS, TEXAS 75244
TEL: 972.788.1000
FAX: 972.788.1302

CONSTRUCTION DOCUMENTS
100% BID SET


ISSUE DATE: NOVEMBER 1, 2002

REVISION	DESCRIPTION	DATE
1	ASI #1	8-5-03
2	ADD-ALT #1	10-7-03
3	ASI #22	2-3-04

SITE PLAN

A001

DATE: 11/01/02 11:57:08 PLOTTED: 02/04/04
FILENAME: K7

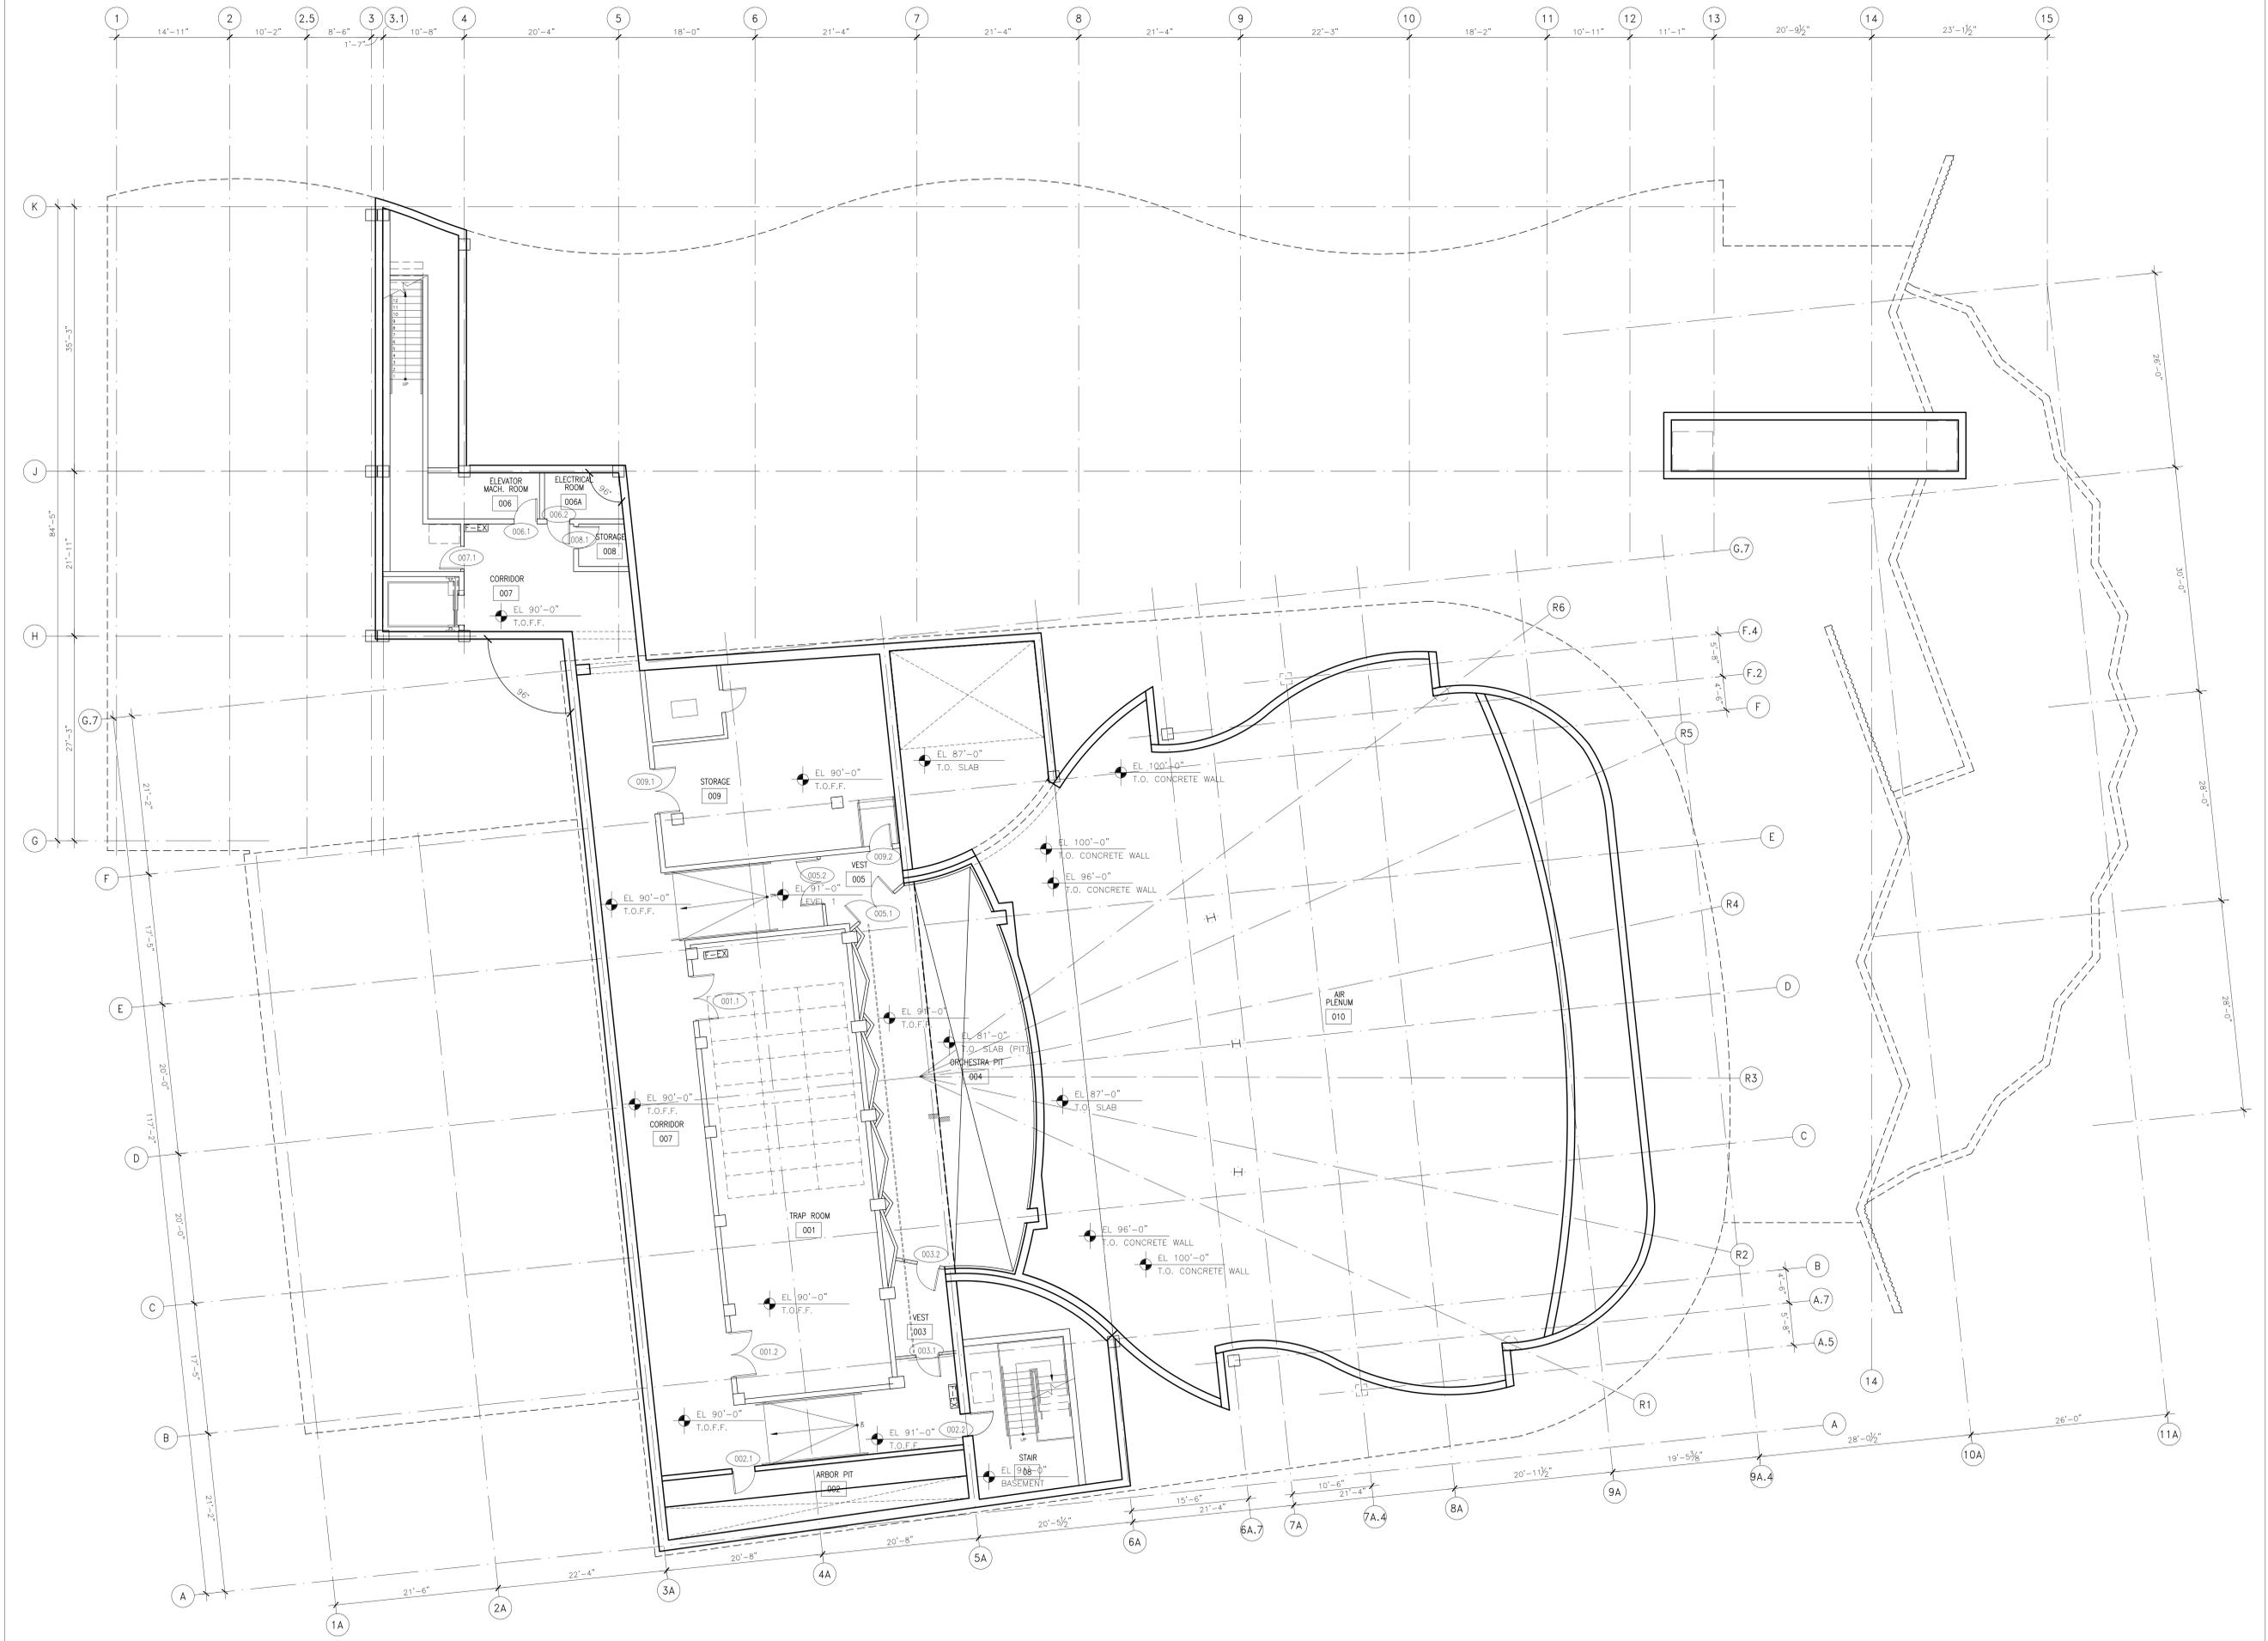

1 BASEMENT PLAN
SCALE 1/8"=1'-0"

SOUTHWEST CENTER FOR THE PERFORMING ARTS

AMARILLO, TEXAS

ARCHITECT OF RECORD:
HOLZMAN MOSS ARCHITECTURE
214 WEST 20TH STREET TOWER, 17th FLOOR
NEW YORK, NEW YORK 10011
www.holzmannoss.com
TEL: 212 465 2800 FAX: 212 465 2200

MECHANICAL, ELECTRICAL, PLUMBING, & FIRE PROTECTION ENGINEERS:
HLM DESIGN
2711 NORTH HASKELL AVENUE SUITE 2200
DALLAS, TEXAS 75204
TEL: 214 454 3800 FAX: 214 454 8707

STRUCTURAL ENGINEERS:
ARCHITECTURAL ENGINEERS COLLABORATIVE
LITTLEFIELD BUILDING 106 EAST SIXTH STREET SUITE 400
AUSTIN, TEXAS 78701
TEL: 512 472 2111 FAX: 512 472 2122

ACOUSTICIAN:
JAFFE HOLDEN ACOUSTICS, INC.
114A WASHINGTON STREET
MORRISVILLE, NORTH CAROLINA 27554
TEL: 303 838 4187 FAX: 303 838 4188

THEATER CONSULTANT:
ROBERT DAVIS, INC.
37 WEST 20TH STREET
NEW YORK, NEW YORK 10011
TEL: 212 242 2855 FAX: 212 242 2743

CIVIL ENGINEERS:
PARKHILL SMITH & COOPER
801 S. HILLMOORE, SUITE 400
AMARILLO, TEXAS 79101
TEL: 806 376 8800 FAX: 806 376 8700

FIRE PROTECTION:
ROLF JENSEN & ASSOCIATES INC.
13811 NORTHWEST FREEWAY, SUITE 330
HOUSTON, TEXAS 77040-2415
TEL: 713 462 1840 FAX: 713 462 0812

SPECIFICATIONS:
CONSTRUCTION SPECIFICATIONS INC.
22 TENANT ROAD, P.O. BOX 488
MORRISVILLE, NEW JERSEY 07911
TEL: 732 370 0700 FAX: 732 370 0700

CONSTRUCTION MANAGER:
HUNT CONSTRUCTION GROUP
4908 BAYVIEW ROAD, SUITE 400
DALLAS, TEXAS 75244
TEL: 972 788 1000 FAX: 972 788 1002

ALL RIGHTS RESERVED. WVDY HOLZMAN PREFERRED SUPPLIER LOGO 2001

CONSTRUCTION DOCUMENTS
100% BID SET


ISSUE DATE:	NOVEMBER 1, 2002	DATE
REVISION:	DESCRIPTION	DATE

BASEMENT FLOOR PLAN

A100
HPFS # 5767.00 PLOTTED: 05/04/02 10:48 AM
FILENAME: 1,7

SOUTHWEST CENTER FOR THE PERFORMING ARTS

AMARILLO, TEXAS

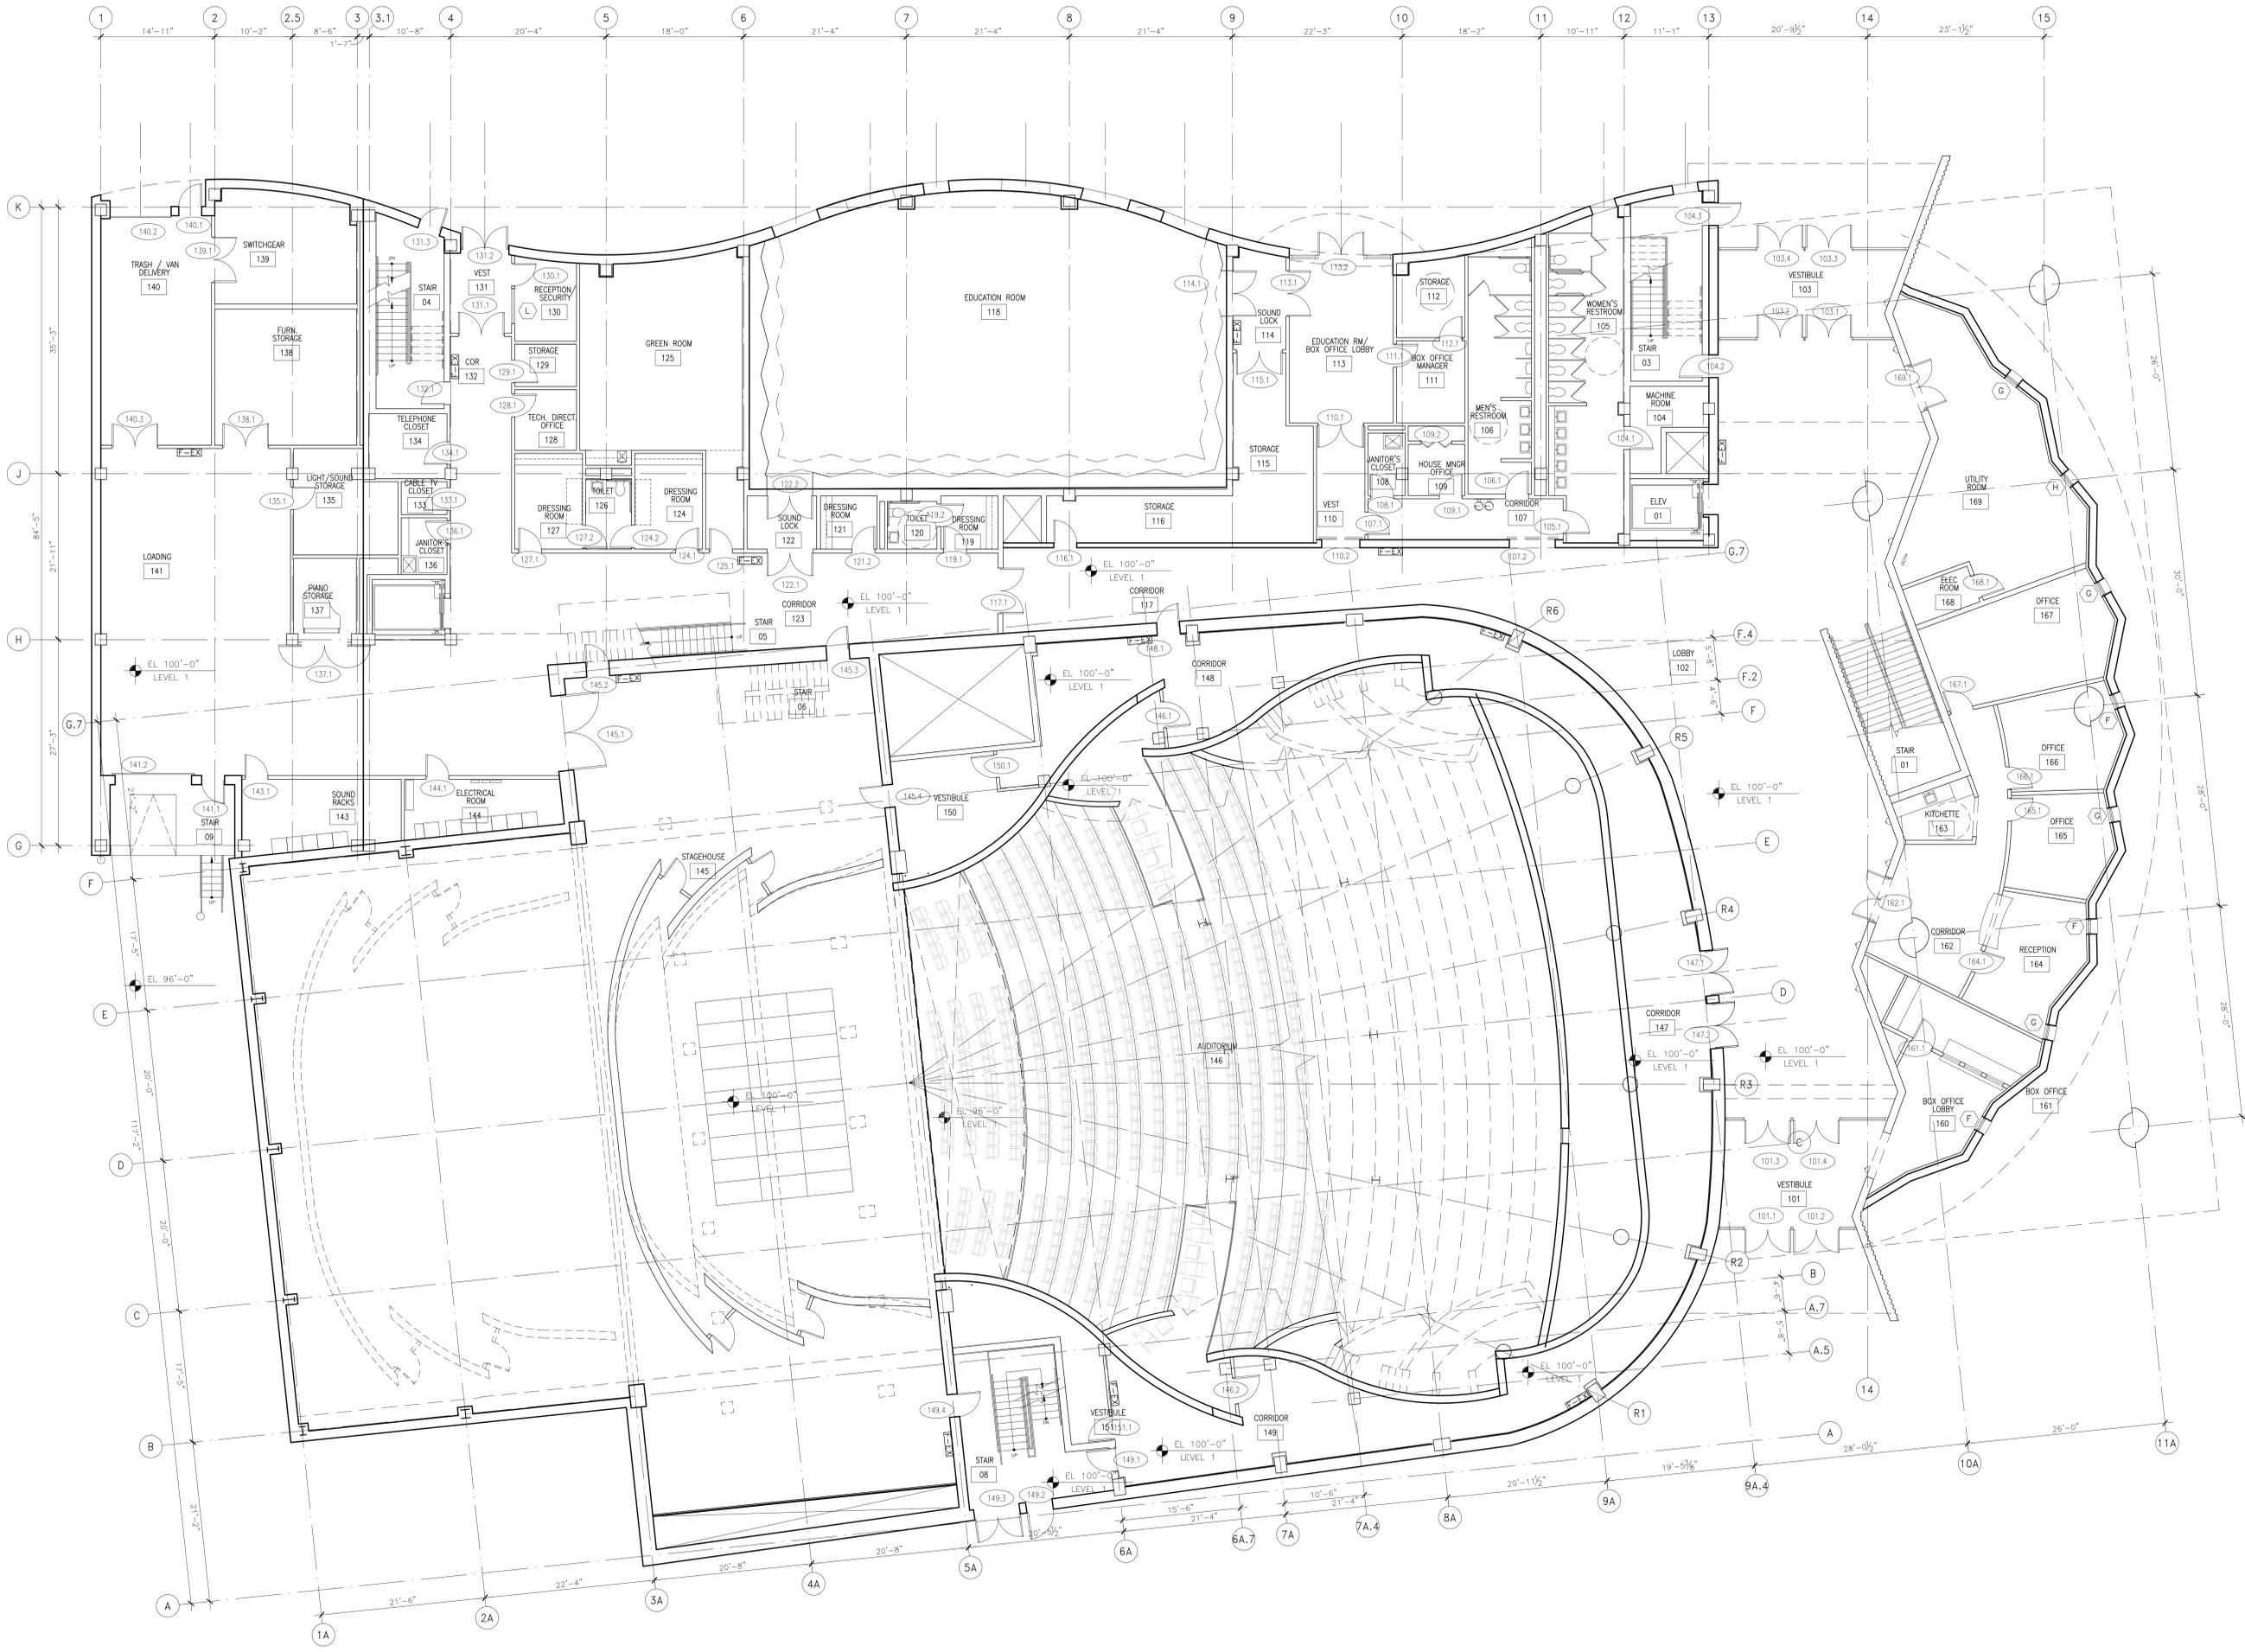

1 ENTRY LEVEL PLAN
SCALE 1/8"=1'-0"



ARCHITECT OF RECORD:
HOLZMAN MOSS ARCHITECTURE
HOLZMAN MOSS ARCHITECTURE, L.P.
214 WEST 29TH STREET TOWER, 17TH FLOOR
NEW YORK, NEW YORK 10001
NEW YORK OFFICE: TEL: 212.465.2200 FAX: 212.465.2228
NEW YORK OFFICE: TEL: 212.465.0888 FAX: 212.465.2228

MECHANICAL, ELECTRICAL, PLUMBING, & FIRE PROTECTION ENGINEER:
RLM DESIGN
2111 NORTH WHEELER AVENUE SUITE 2000
DALLAS, TEXAS 75204
DALLAS OFFICE: TEL: 214.824.3800 FAX: 214.824.8707

STRUCTURAL ENGINEERS:
ARCHITECTURAL ENGINEERS COLLABORATIVE
LITTLEFIELD BUILDING
100 EAST 60TH STREET
AUSTIN, TEXAS 78701
AUSTIN OFFICE: TEL: 512.472.2111 FAX: 512.472.2122

ACOUSTICIAN:
JAFFE HOLDEN ACOUSTICS, INC.
1144 WASHINGTON STREET
NORWALK, CONNECTICUT 06854
NORWALK OFFICE: TEL: 203.858.4167 FAX: 203.858.4168

THEATER CONSULTANT:
ROBERT DAVIS, INC.
37 WEST 20TH STREET
NEW YORK, NEW YORK 10011
NEW YORK OFFICE: TEL: 212.628.8959 FAX: 212.628.2743

CIVIL ENGINEERS:
PARKHILL SMITH & COOPER
801 S. FILLMORE, SUITE 400
AMARILLO, TEXAS 79101
AMARILLO OFFICE: TEL: 806.378.8600 FAX: 806.378.8700

FIRE PROTECTION:
ROFF HENSEN & ASSOCIATES INC.
1301 NORTHWEST FREEDWAY, SUITE 330
HOUSTON, TEXAS 77040-5215
HOUSTON OFFICE: TEL: 713.462.1840 FAX: 713.462.8812

SPECIFICATIONS:
CONSTRUCTION SPECIFICATIONS INC.
20 THORNHILL ROAD, P.O. BOX 406
MORGANVILLE, NEW JERSEY 07951
MORGANVILLE OFFICE: TEL: 908.526.0770 FAX: 908.526.0790

CONSTRUCTION MANAGER:
HUNT CONSTRUCTION GROUP
4099 MAEVEN ROAD, SUITE 400
DALLAS, TEXAS 75244
DALLAS OFFICE: TEL: 972.788.1000 FAX: 972.788.1302

ALL RIGHTS RESERVED BY HOLZMAN MOSS ARCHITECTS L.P. 2002

CONSTRUCTION DOCUMENTS
100% BID SET


ISSUE DATE: NOVEMBER 1, 2002

REVISION	DESCRIPTION	DATE
1	ASI 028	4-20-04
2	ASI 028A	8-31-04

FIRST FLOOR PLAN

A101

INSET: 1/8" = 1/8" (1/8" = 1/8") PLOTTED: 02/04/04
FILENAME: K7

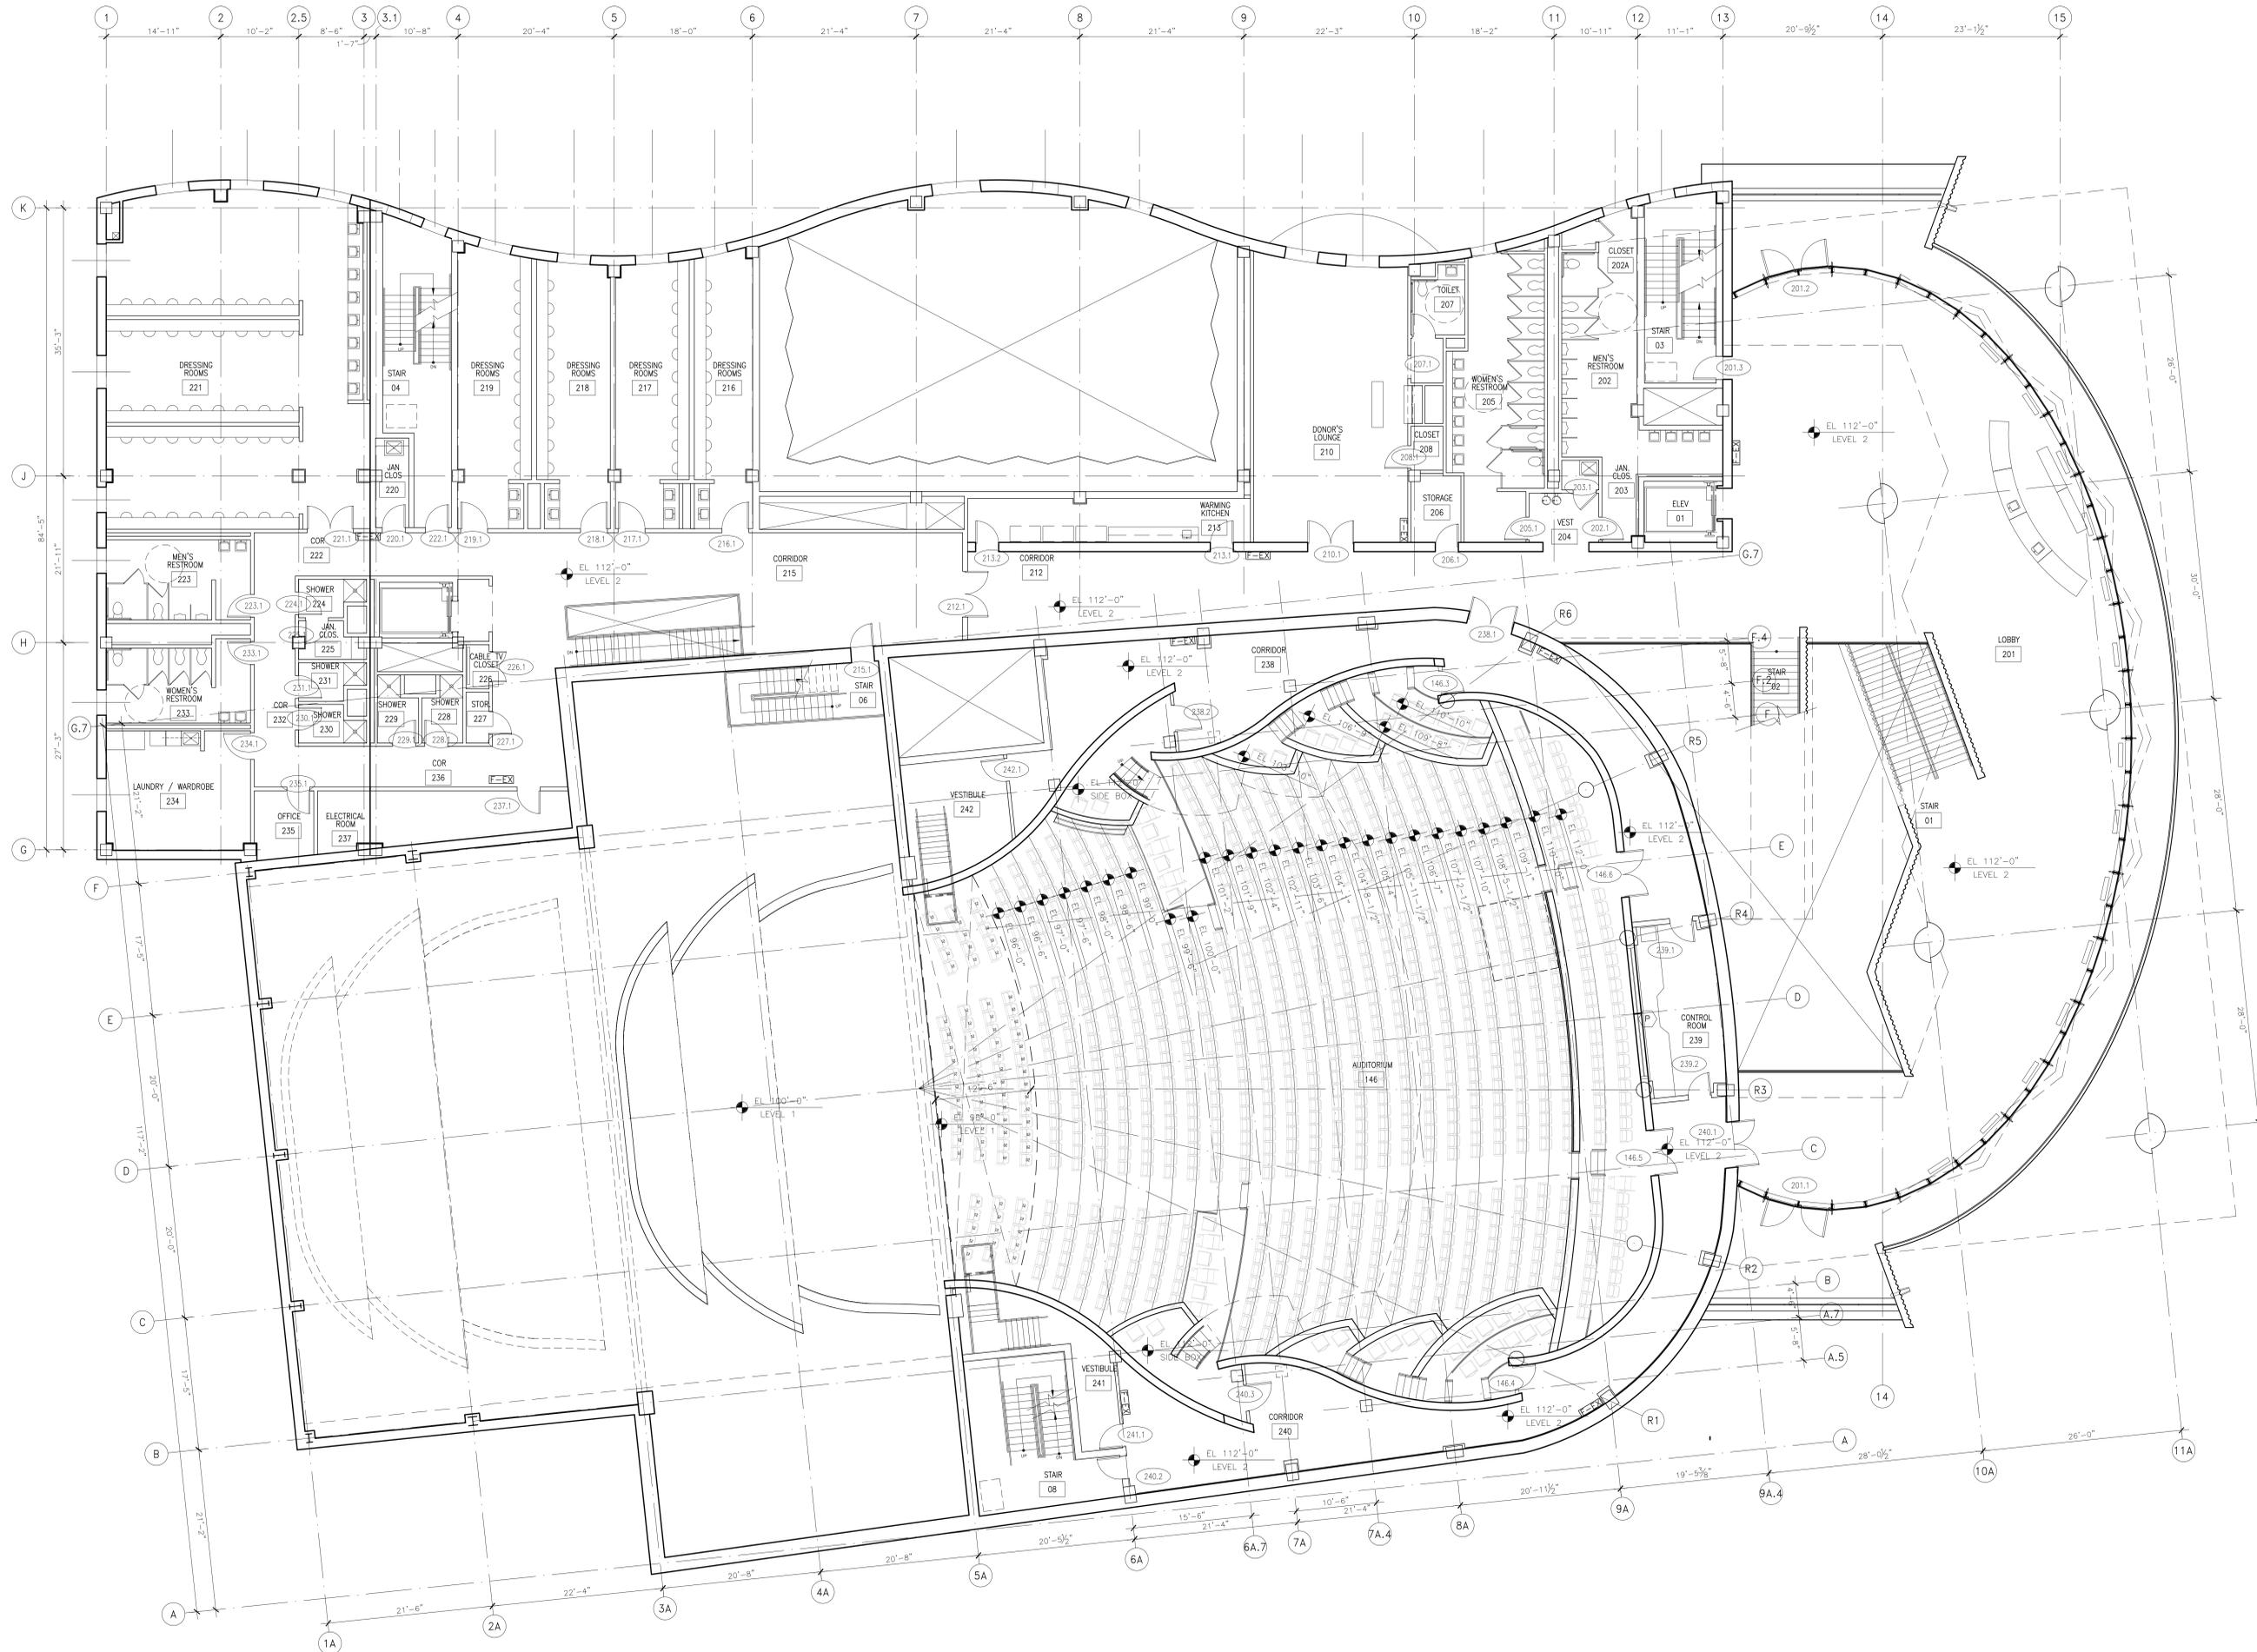

1 SECOND LEVEL PLAN
SCALE 1/8" = 1'-0"

SOUTHWEST CENTER FOR THE PERFORMING ARTS

AMARILLO, TEXAS

ARCHITECT OF RECORD:
HOLZMAN MOSS ARCHITECTURE
 178 FLOOR
 NEW YORK, NEW YORK 10001
 WWW.HOLZMANMOSS.COM
 TEL: 212.465.9808 FAX: 212.465.2226

MECHANICAL, ELECTRICAL, PLUMBING, & FIRE PROTECTION ENGINEERS:
HJM DESIGN
 5117 NORTH HARVELL AVENUE SUITE 200
 DALLAS, TEXAS 75204
 TEL: 214.824.2800
 FAX: 214.824.8707

STRUCTURAL ENGINEERS:
ARCHITECTURAL ENGINEERS COLLABORATIVE
 LITTLEFIELD BUILDING
 108 EAST 50TH STREET SUITE 400
 AUSTIN, TEXAS 78701
 TEL: 512.472.2111
 FAX: 512.472.2122

ACOUSTIC CONSULTANT:
JAFTE HOLDEN ACOUSTICS, INC.
 114A WASHINGTON STREET
 NORWALK, CONNECTICUT 06854
 TEL: 203.838.6187
 FAX: 203.838.4188

THEATER CONSULTANT:
ROBERT DAVIS, INC.
 37 WEST 20TH STREET
 NEW YORK, NEW YORK 10011
 TEL: 212.824.2800
 FAX: 212.824.2743

CIVIL ENGINEERS:
PARKHILL SMITH & COOPER
 801 S. FILLMORE, SUITE 400
 AMARILLO, TEXAS 79101
 TEL: 806.376.8500
 FAX: 806.376.8700

FIRE PROTECTION:
ROLF JENSEN & ASSOCIATES INC.
 1303 NORTHWEST FREEDAY, SUITE 330
 HOUSTON, TEXAS 77040-2515
 TEL: 713.462.1840
 FAX: 713.462.0812

SPECIFICATIONS:
CONSTRUCTION SPECIFICATIONS INC.
 25 TERRYMAN ROAD, P.O. BOX 448
 MORRISVILLE, NEW JERSEY 07951
 TEL: 732.878.0700
 FAX: 732.878.0700


CONSTRUCTION MANAGER:
HUNT CONSTRUCTION GROUP
 4099 MAEWEEN ROAD, SUITE 400
 DALLAS, TEXAS 75244
 TEL: 972.788.9000
 FAX: 972.788.1302

CONSTRUCTION DOCUMENTS
 100% BID SET

ISSUE DATE:	NOVEMBER 1, 2002
REVISION:	DESCRIPTION DATE

SECOND LEVEL PLAN

A102

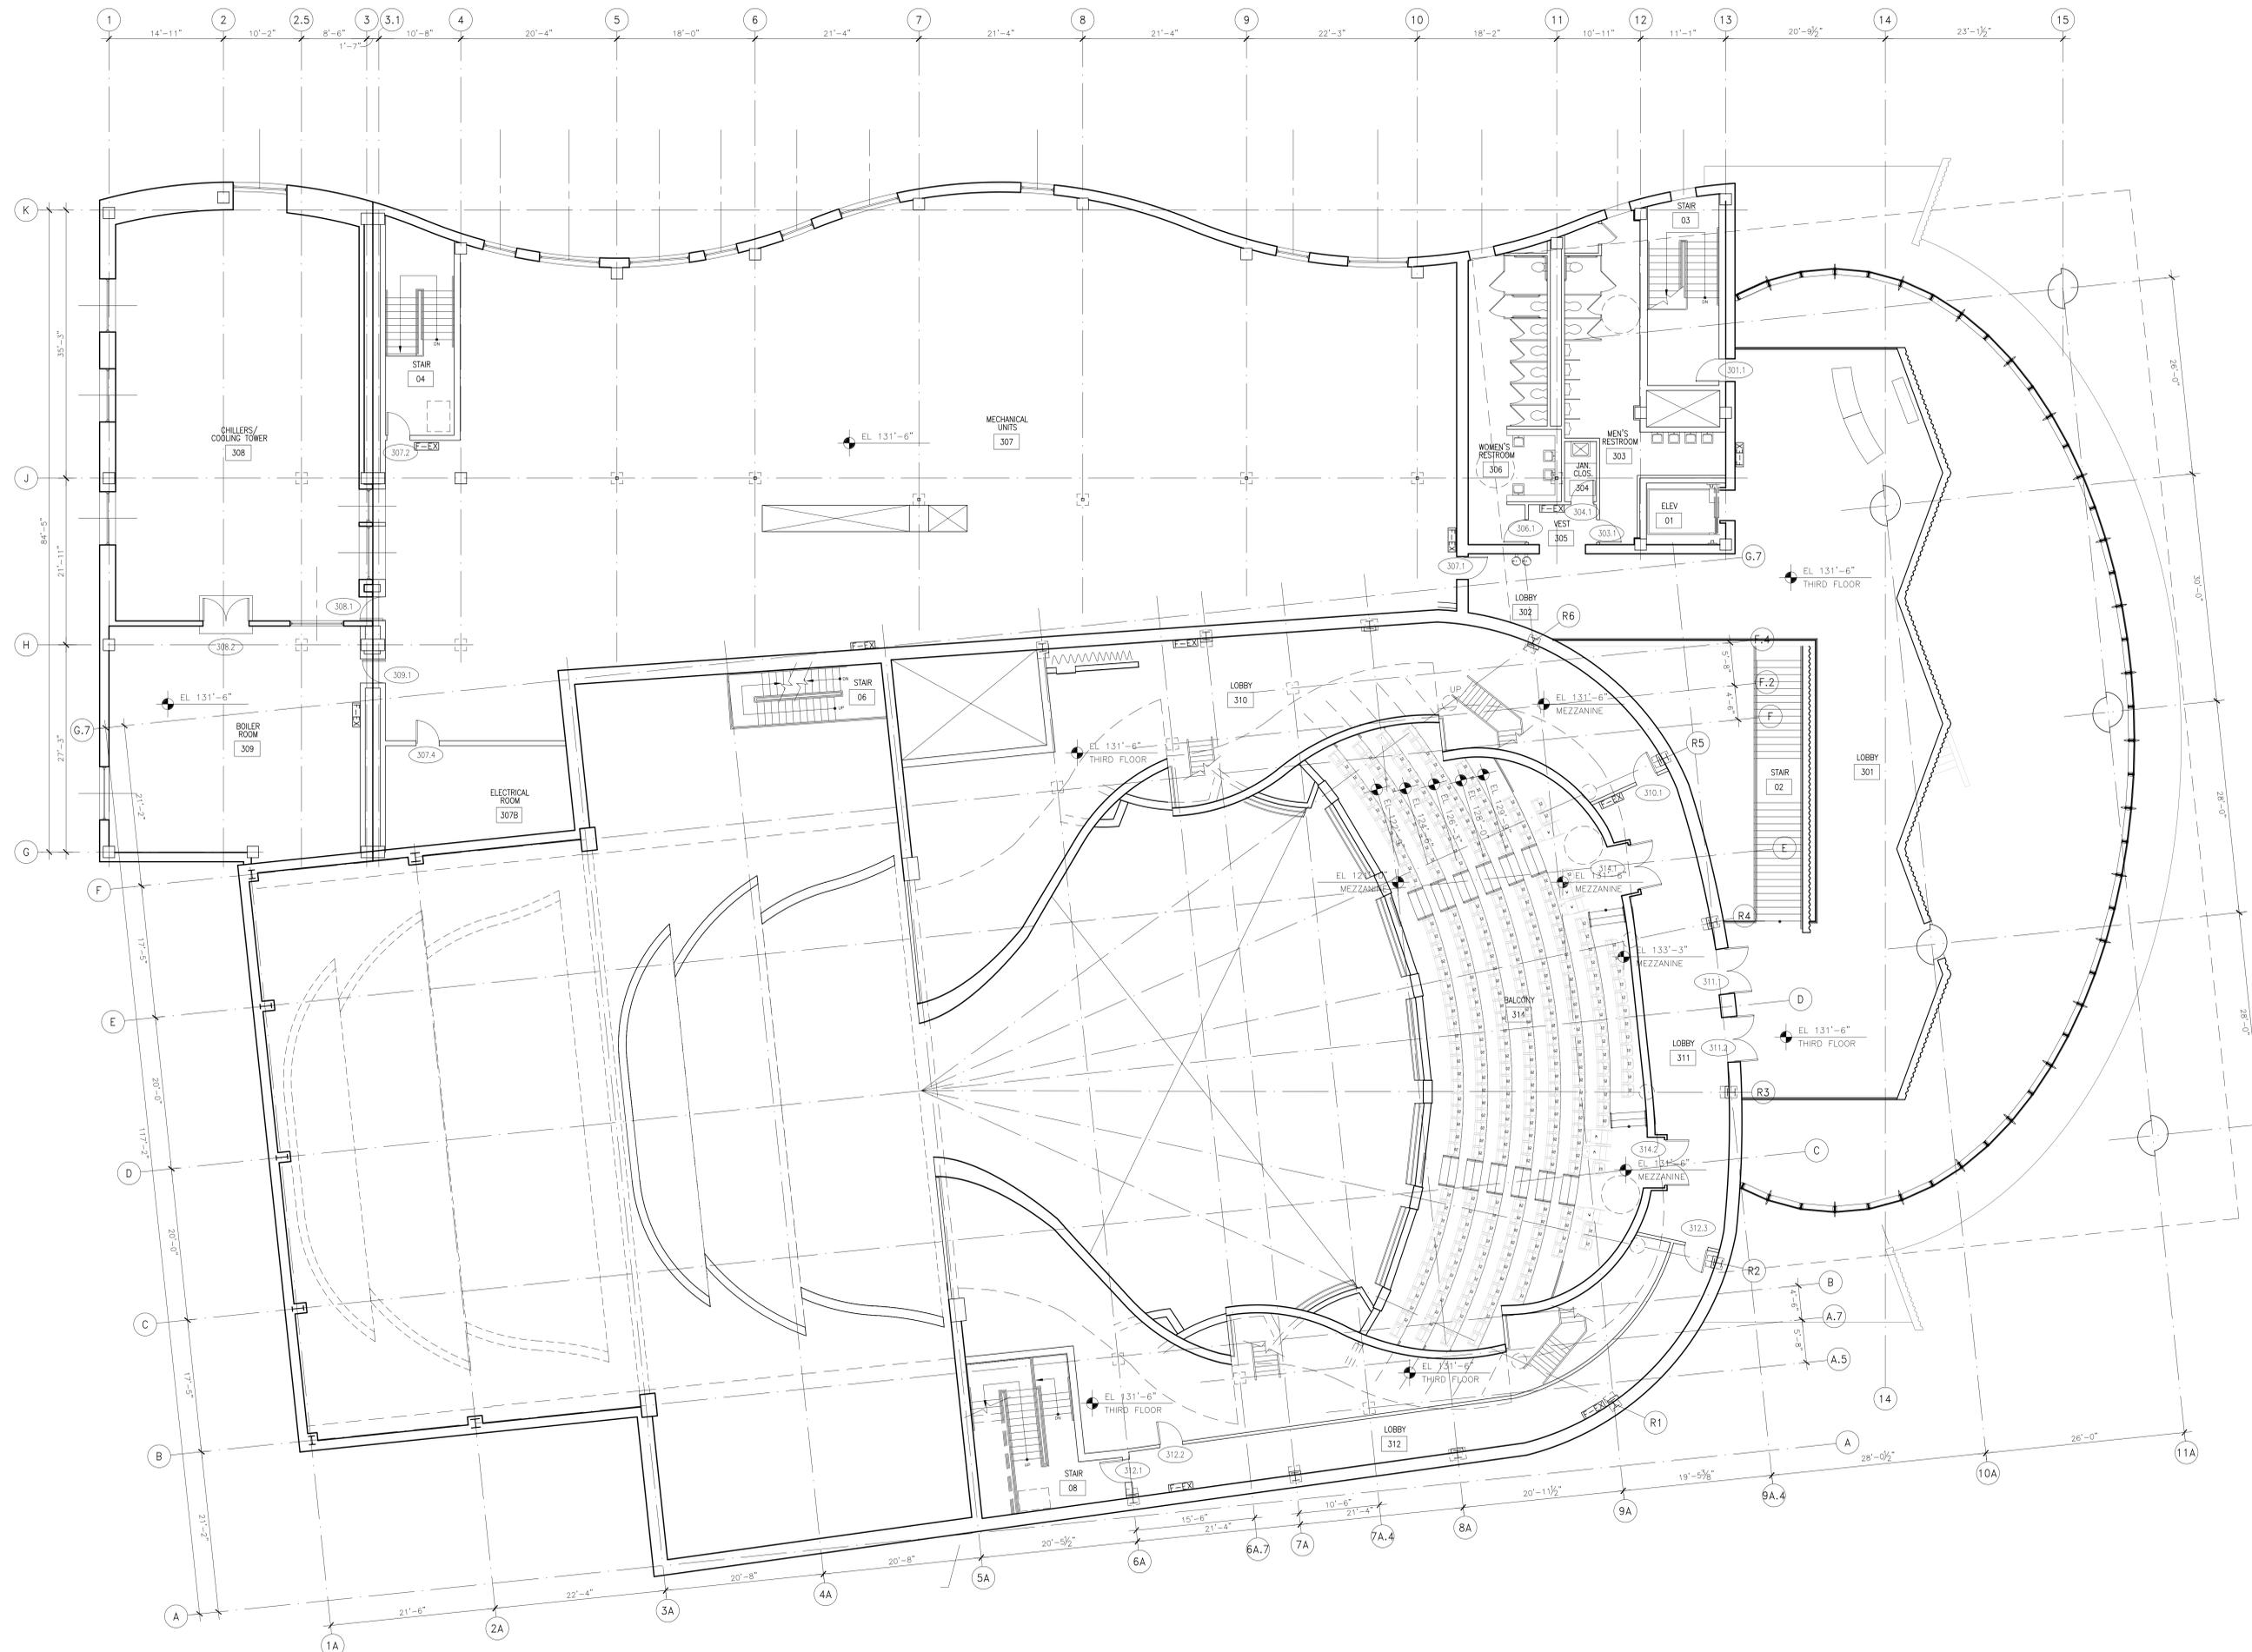

1 THIRD LEVEL PLAN
SCALE 1/8"=1'-0"

SOUTHWEST CENTER FOR THE PERFORMING ARTS

AMARILLO, TEXAS

ARCHITECT OF RECORD:
HOLZMAN MOSS ARCHITECTURE
 214 WEST 20TH STREET, TOWER
 17th FLOOR
 NEW YORK, NEW YORK 10011
 www.holzmannoss.com
 TEL: 212 465 9808 FAX: 212 465 2205

MECHANICAL, ELECTRICAL, PLUMBING, & FIRE PROTECTION ENGINEERS:
HLM DESIGN
 2711 NORTH HASSELL AVENUE SUITE 2200
 DALLAS, TEXAS 75244
 TEL: 214 454 3800
 FAX: 214 454 8707

STRUCTURAL ENGINEERS:
ARCHITECTURAL ENGINEERS COLLABORATIVE
 LITTLEFIELD BUILDING SUITE 450
 106 EAST SIXTH STREET
 AUSTIN, TEXAS 78701
 TEL: 512 472 2111
 FAX: 512 472 2122

ACOUSTICIAN:
JAFFE HOLDEN ACOUSTICS, INC.
 114A WASHINGTON STREET
 MORRISVILLE, CONNECTICUT 06044
 TEL: 203 858 4187
 FAX: 203 858 4188

THEATER CONSULTANT:
ROBERT DAVIS, INC.
 37 WEST 20TH STREET
 NEW YORK, NEW YORK 10011
 TEL: 212 242 9855
 FAX: 212 242 9743

CIVIL ENGINEERS:
PARKHILL SMITH & COOPER
 801 S. HILLMOORE, SUITE 400
 AMARILLO, TEXAS 79101
 TEL: 806 376 8800
 FAX: 806 376 8700

FIRE PROTECTION:
ROLF JENSEN & ASSOCIATES INC.
 13831 NORTHWEST FREEWAY, SUITE 330
 HOUSTON, TEXAS 77060-0215
 TEL: 713 462 1940
 FAX: 713 462 0812

SPECIFICATIONS:
CONSTRUCTION SPECIFICATIONS INC.
 22 TENANT ROAD, P.O. BOX 488
 MORRISVILLE, NEW JERSEY 07911
 TEL: 732 370 0700
 FAX: 732 370 0700

CONSTRUCTION MANAGER:
HUNT CONSTRUCTION GROUP
 408 BAYVIEW ROAD, SUITE 400
 DALLAS, TEXAS 75244
 TEL: 972 788 1000
 FAX: 972 788 1002

ALL RIGHTS RESERVED. WWD+HOLZMAN PREFERRED ASSOCIATES L.P. 2001


CONSTRUCTION DOCUMENTS
100% BID SET

ISSUE DATE:	NOVEMBER 1, 2002	DATE
REVISION:	DESCRIPTION	DATE

THIRD LEVEL PLAN

A104

HPS # 5767.00 PLOTTED: 05/04/04
FILENAME: 67

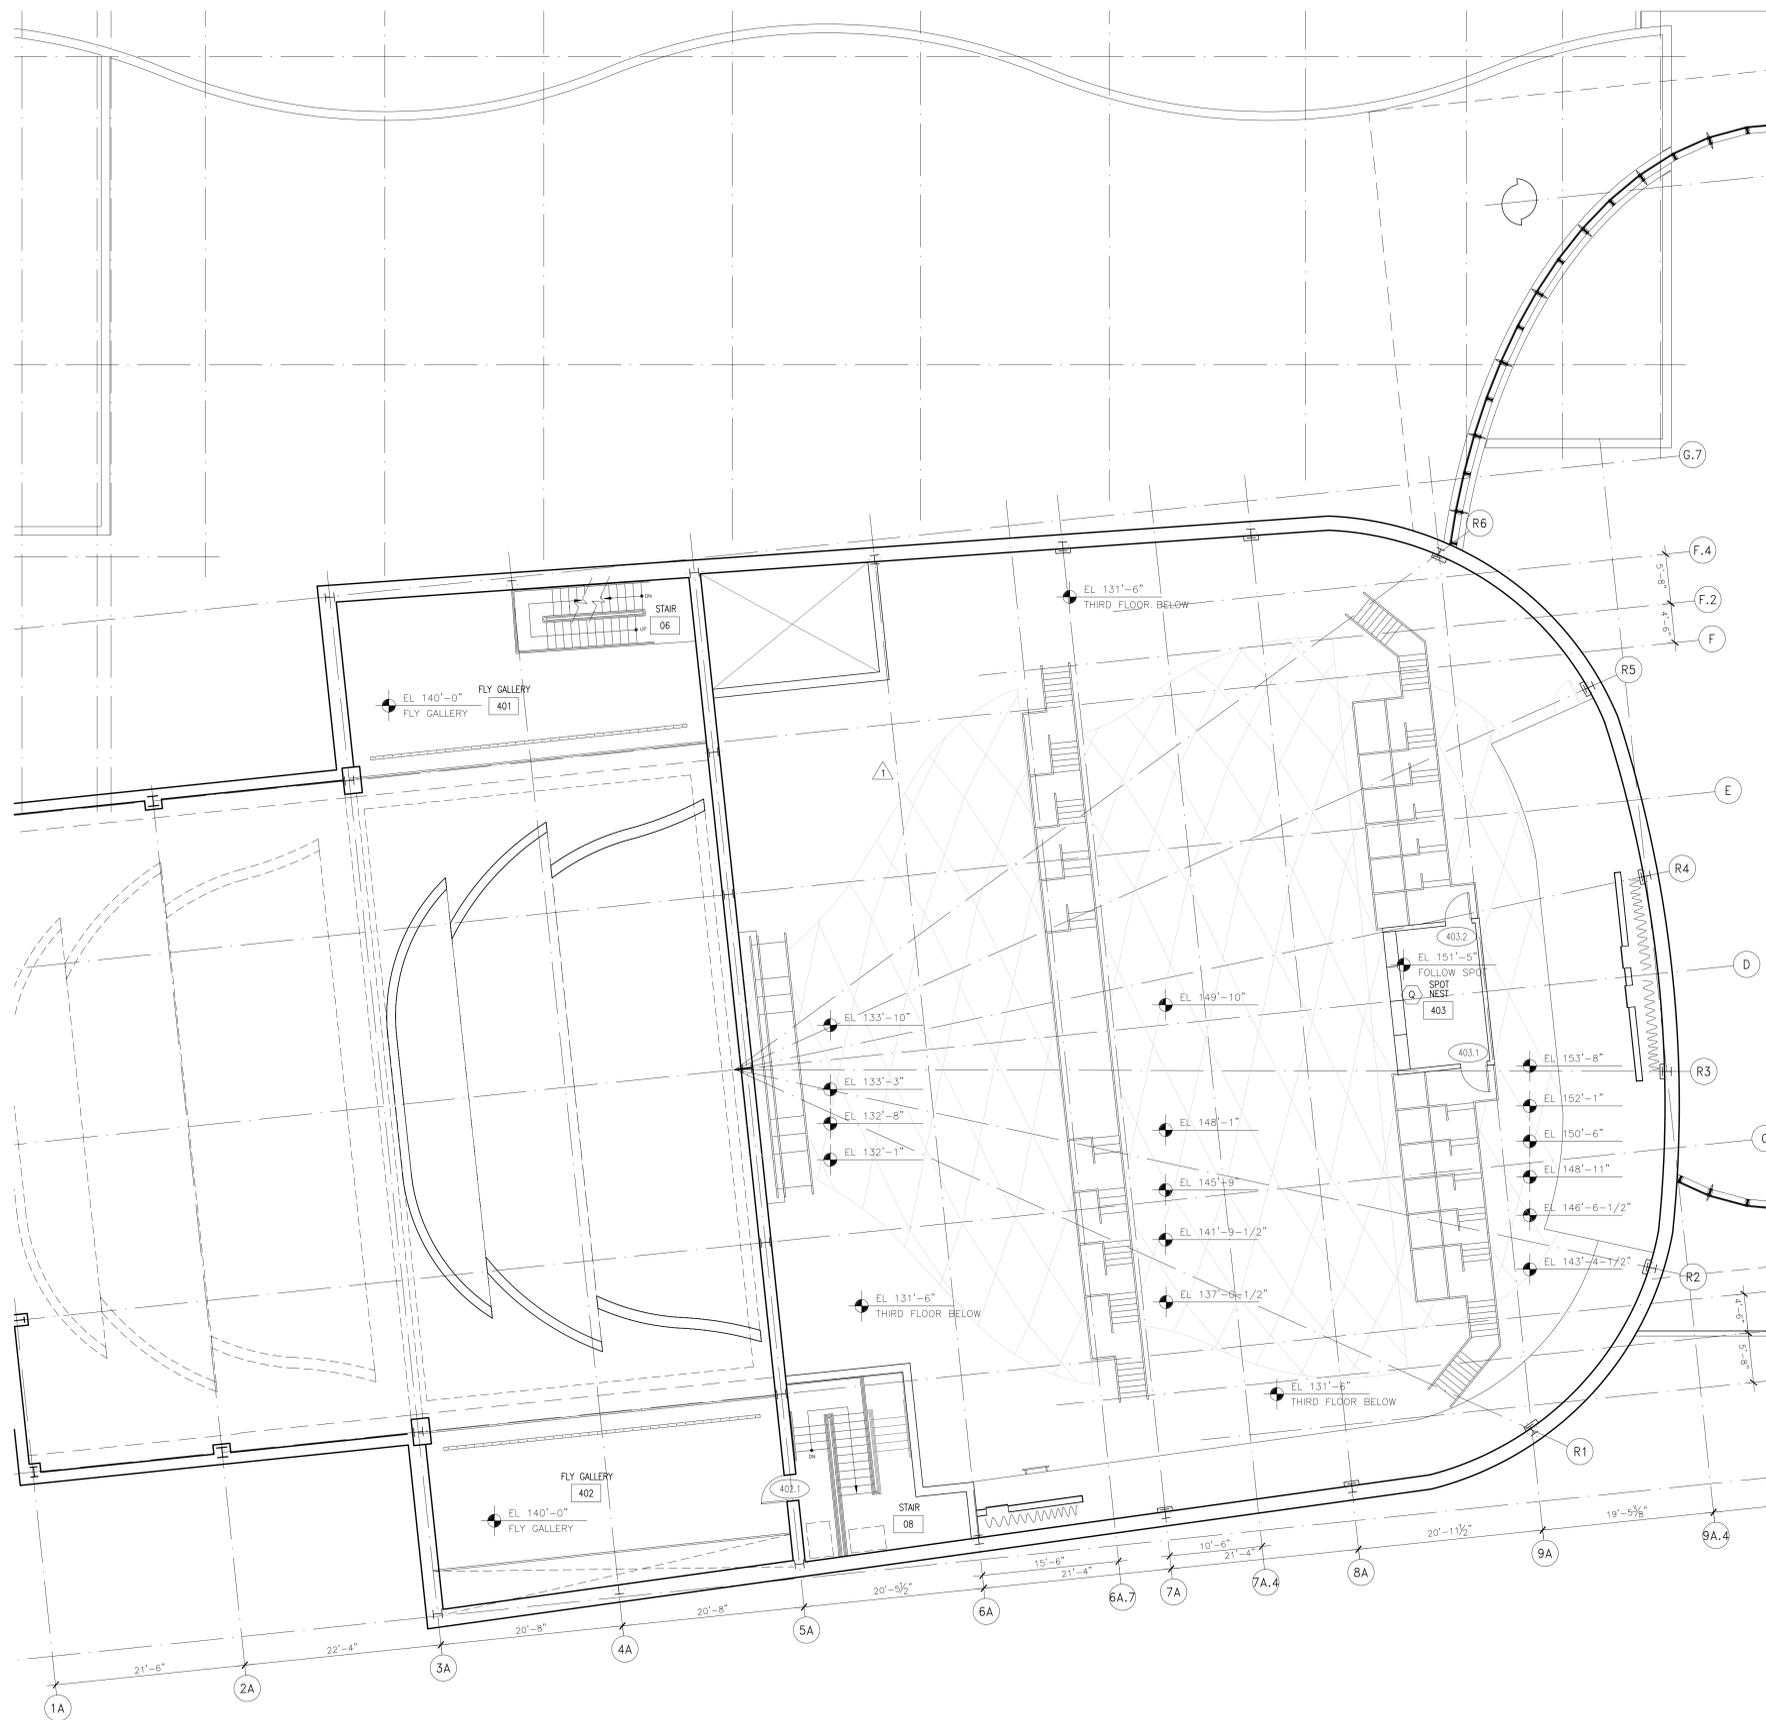

1 FLY GALLERIES/ CATWALKS
SCALE 1/8"=1'-0"



2 GRIDIRON PLAN
SCALE 1/8"=1'-0"



SOUTHWEST CENTER FOR THE PERFORMING ARTS

AMARILLO, TEXAS

ARCHITECT OF RECORD:
HOLZMAN MOSS ARCHITECTURE
214 WEST 20TH STREET TOWER
215 FLOOR
NEW YORK, NEW YORK 10011
WWW.HOLZMANMOSS.COM
TEL: 212.465.9808 FAX: 212.465.2228

MECHANICAL, ELECTRICAL, PLUMBING, & FIRE PROTECTION ENGINEER:
HLM DESIGN
3177 NORTH HARBELL AVENUE SUITE 200
DALLAS, TEXAS 75244
TEL: 214.824.3900
FAX: 214.824.8707

STRUCTURAL ENGINEER:
ARCHITECTURAL ENGINEERS COLLABORATIVE
LITTLEFIELD BUILDING
108 EAST 56TH STREET SUITE 400
AUSTIN, TEXAS 78751
TEL: 512.472.2111
FAX: 512.472.2122

ACOUSTIC CONSULTANT:
JAFFE HOLDEN ACOUSTICS, INC.
1144 WASHINGTON STREET
NORWALK, CONNECTICUT 06854
TEL: 203.838.4187
FAX: 203.838.4188

THEATER CONSULTANT:
ROBERT DAVIS, INC.
37 WEST 20TH STREET
NEW YORK, NEW YORK 10011
TEL: 212.922.8869
FAX: 212.924.2743

CIVIL ENGINEER:
PARKHILL SMITH & COOPER
801 S. FILLMORE, SUITE 400
AMARILLO, TEXAS 79101
TEL: 806.376.8500
FAX: 806.376.8700

FIRE PROTECTION:
ROLF JENSEN & ASSOCIATES INC.
1305 NORTHWEST FREEWAY, SUITE 330
HOUSTON, TEXAS 77040-0215
TEL: 713.462.1840
FAX: 713.462.0812

SPECIFICATIONS:
CONSTRUCTION SPECIFICATIONS INC.
25 TERNWAY ROAD, #10, 08048
MORGANVILLE, NEW JERSEY 07951
TEL: 762.891.0191
FAX: 762.891.0790

CONSTRUCTION MANAGER:
HUNT CONSTRUCTION GROUP
4099 WHEWEN ROAD, SUITE 400
DALLAS, TEXAS 75244
TEL: 972.788.1000
FAX: 972.788.1302

ALL RIGHTS RESERVED. HONEY HOLZMAN PEREPE ASSOCIATES LLP 2002

CONSTRUCTION DOCUMENTS

100% BID SET

ISSUE DATE:	NOVEMBER 1, 2002
REVISION:	DESCRIPTION DATE
△	CATWALK 10-1-03

FLY GALLERY, CATWALK, AND GRIDIRON PLAN

A105

HPHA 5-27-03 PLOTTED: 10/20/04
FILENAME: K7